


TIP PROJECT: B-5929

CONTRACT: DN01162

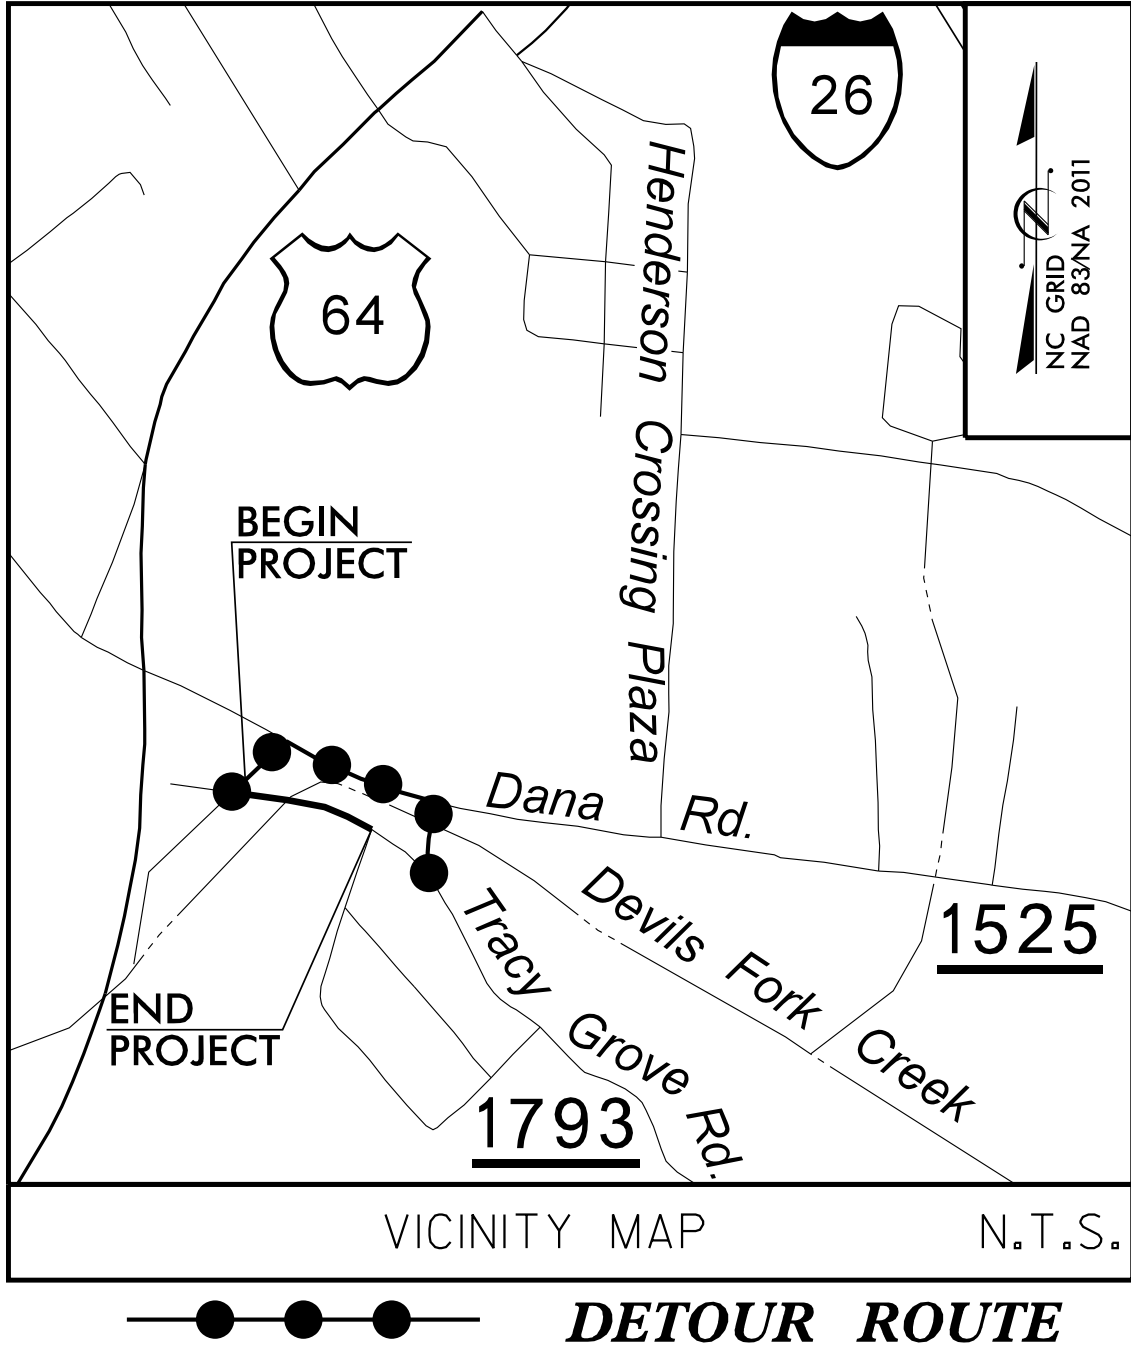

STATE OF NORTH CAROLINA
DIVISION OF HIGHWAYS


UTILITY CONSTRUCTION PLANS HENDERSON COUNTY

LOCATION: BRIDGE NO. 440350 OVER DEVILS FORK CREEK
ON TRACY GROVE ROAD (S.R. 1793)


TYPE OF WORK: WATER & SEWER LINE CONSTRUCTION;
WATER LINE REMOVAL & SEWER LINE
REMOVAL /ABANDONMENT

T.I.P. NO.	SHEET NO.
B-5929	UC-1

UTILITY CONST. PLANS
DATE: AUGUST 24, 2026

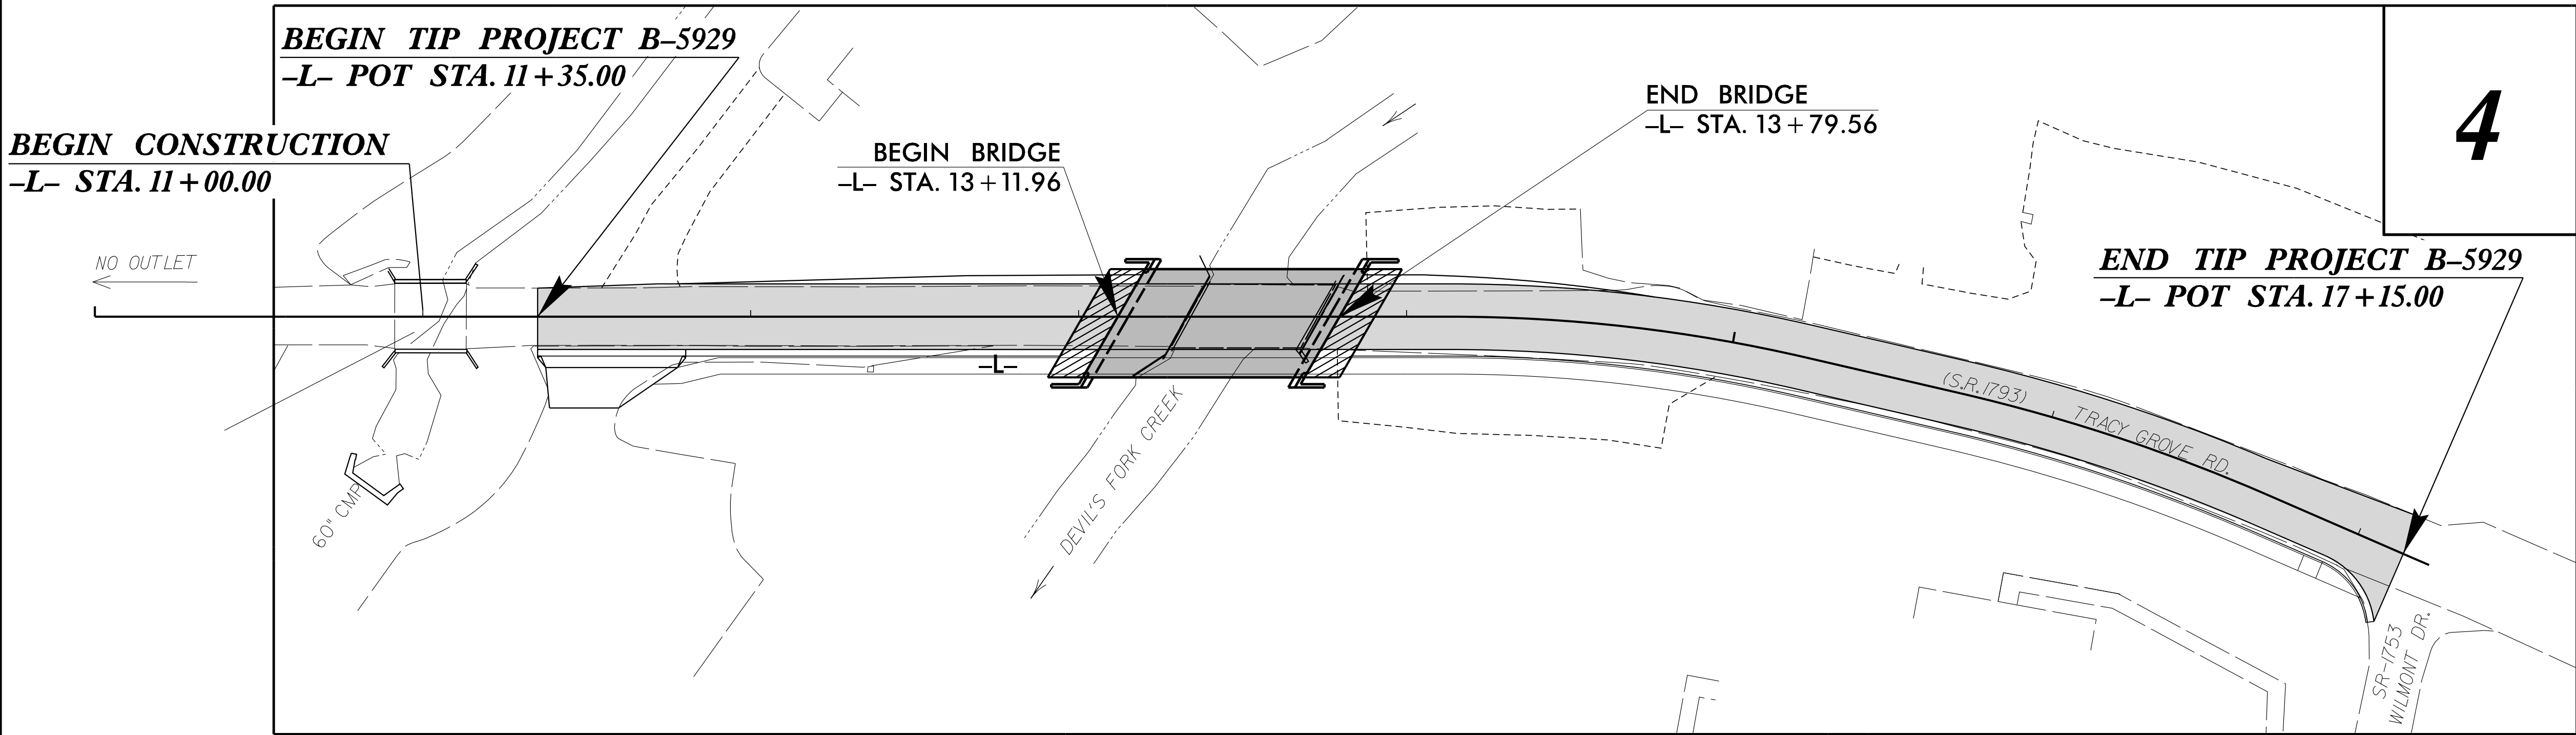

DOCUMENT NOT CONSIDERED FINAL
UNTIL ALL SIGNATURES ARE COMPLETED

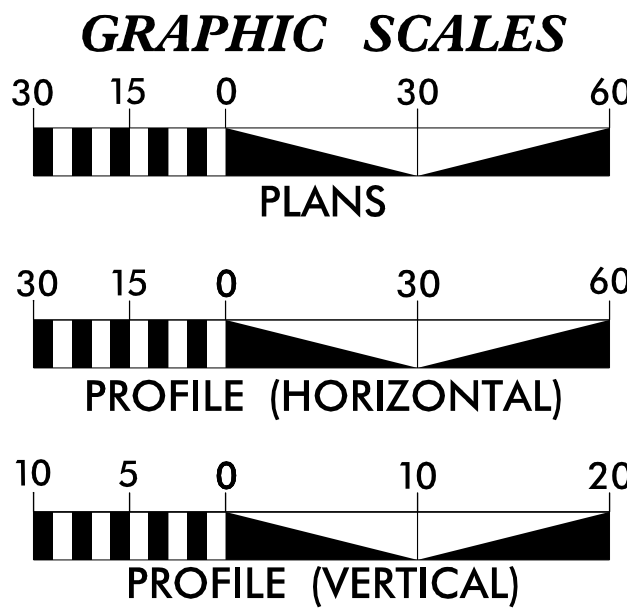

SHEET NO.	DESCRIPTION
UC-1	TITLE SHEET
UC-2	UTILITY SYMBOLOGY
UC-3 - UC-3A	NOTES
UC-3B - UC-3E	DETAILS
UC-4 - UC-4A	UTILITY PLAN & PROFILE

UTILITY OWNERS ON PROJECT
(1) WATER & SEWER - CITY OF HENDERSONVILLE

Prepared in the Office of:
JOHNSON, MIRMIRAN, & THOMPSON, INC. SEAL:
2550 West Tyvola Road, Suite 120,
Charlotte NC, 28217

JMT

Marie Peedin, P.E. UTILITY PROJECT ENGINEER
Nicholas Asaro, PLS PROJECT UTILITY COORDINATOR
Emily Morris, E.I. PROJECT UTILITY DESIGNER

STATE OF NORTH CAROLINA
DIVISION OF HIGHWAYS
UTILITIES UNIT
1555 MAIL SERVICES CENTER
RALEIGH, NC 27699-1555
PHONE (919) 707-6690
FAX (919) 250-4151

Byron Sanders, P.E. UTILITIES REGIONAL ENGINEER
Bob Golding DIVISION UTILITIES ENGINEER
Amy Dupree UTILITIES AREA COORDINATOR
Bill Green DIVISION UTILITIES COORDINATOR